

STATE OF MISSISSIPPI  
MISSISSIPPI DEPARTMENT OF TRANSPORTATION

**EQUIPMENT SHED AND WAREHOUSE  
AT SHOP COMPLEX IN JACKSON**  
**STATE PROJECT NOS.  
BWO-9039-25(001) & BWO-9040-25(001)**


501963/301000

501977/301000


① 10-15-08  
RE: ① 01-06-09

HINDS COUNTY

FED. ROAD REG. NO.	STATE	PROJECT NO.	SHEET NO.
4	MISS.		1

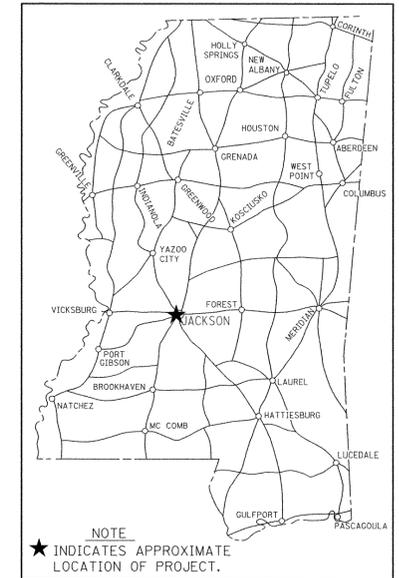

THE ROADWAY DESIGN DIVISION, C.A.D.D. SECTION, MISSISSIPPI DEPARTMENT OF TRANSPORTATION

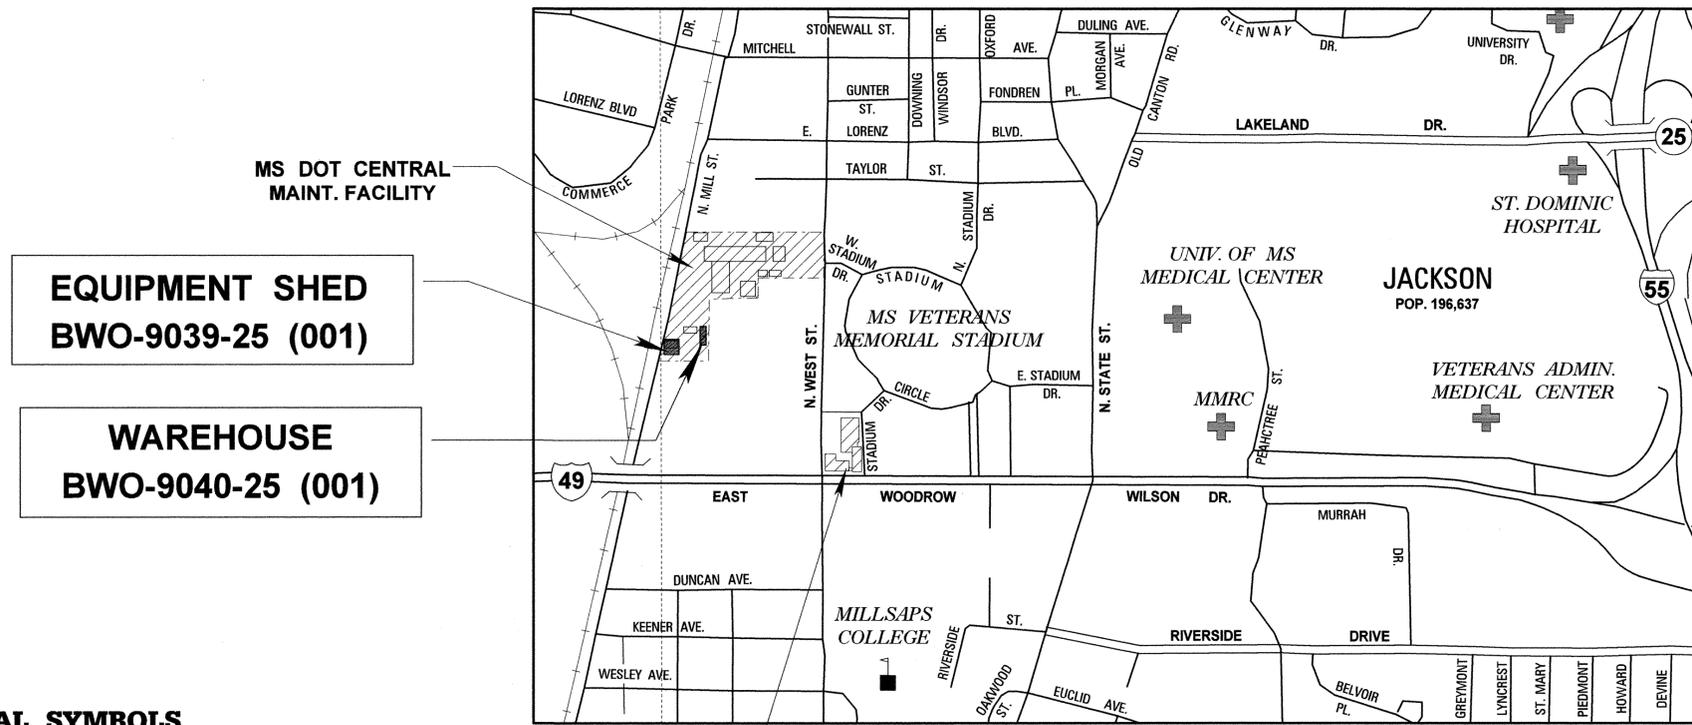

**EQUIPMENT SHED  
BWO-9039-25 (001)**

**WAREHOUSE  
BWO-9040-25 (001)**

**DESIGN CONTROL**

MPH = V (SPEED DESIGN)

ADT ( ) = : ADT ( ) =

DHV = : D = % T = %

**PERMITS ACQUIRED BY MDOT**

WETLANDS AND WATERS PERMITS (NECESSARY FOR ULTIMATE IMPROVEMENTS ONLY):

	WATERS	WETLANDS
NATIONWIDE #14	<input type="checkbox"/>	<input type="checkbox"/>
NATIONWIDE (OTHER)*	<input type="checkbox"/>	<input type="checkbox"/>
GENERAL*	<input type="checkbox"/>	<input type="checkbox"/>
INDIVIDUAL (404)*	<input type="checkbox"/>	<input type="checkbox"/>

\* ACQUISITION OF PERMITS FOR TEMPORARY IMPACTS DURING CONSTRUCTION ARE THE RESPONSIBILITY OF THE CONTRACTOR

STORMWATER PERMIT

Y REQUIRED, CNOI SUBMITTED BY MDOT (DISTRIBUTED AREA = 5 ACRES + JN1B 586)

S REQUIRED, SCNOI TO BE SUBMITTED BY CONTRACTOR (1 TO 4.99 ACRES/JN1B 14)

N NO STORMWATER PERMIT REQUIRED (<1 ACRE)

APPROVED BY: *[Signature]* DATE: 10-6-08

**WAREHOUSE**  
N. 1029551.9600  
E. 2342456.6261

**EQUIPMENT SHED**  
N. 1029480.2909  
E. 2342245.3355

**CONVENTIONAL SYMBOLS**

COUNTY LINE -----

TOWN CORPORATION LINE -----

SECTION LINE -----

PROPOSED ROAD OR TRAVELED WAY - - - - -

EXISTING ROAD OR TRAVELED WAY - - - - -

RAILROAD -----

SURVEY LINE -----

BRIDGES -----

APPROVED:	<i>[Signature]</i>	10/10/08
BY:	CHIEF ENGINEER	DATE
APPROVED:	<i>[Signature]</i>	10/10/08
BY:	EXECUTIVE DIRECTOR	DATE
MISSISSIPPI DEPARTMENT OF TRANSPORTATION		
APPROVED:		
DATE	DIVISION ADMINISTRATOR	DATE
	FEDERAL HIGHWAY ADMINISTRATION	DEPARTMENT OF TRANSPORTATION


**DESCRIPTION OF SHEET**

**WKG. NO. SH. NO.**

**ABBREVIATIONS:**

**SYMBOL LEGEND:**

- AFF ..... ABOVE FINISH FLOOR
- BLDG ..... BUILDING
- BOTT ..... BOTTOM
- CJ ..... CONTROL JOINT
- CLR ..... CLEAR
- CONT ..... CONTINUOUS
- DET ..... DETAIL
- DIA ..... DIAMETER
- (E) ..... EXISTING
- EA ..... EACH
- EJ ..... EXPANSION JOINT
- ELEC ..... ELECTRICAL
- EQL ..... EQUAL
- ETR ..... EXISTING TO REMAIN
- EXTR ..... EXTRUDED
- FF ..... FINISH FLOOR
- FT ..... FEET
- GC ..... GENERAL CONTRACTOR
- MECH ..... MECHANICAL
- MET ..... METAL
- NIC ..... NOT IN CONTRACT
- OC ..... ON CENTER
- PL ..... PLATE
- REINF ..... REINFORCING
- SCHD ..... SCHEDULE
- TYP ..... TYPICAL

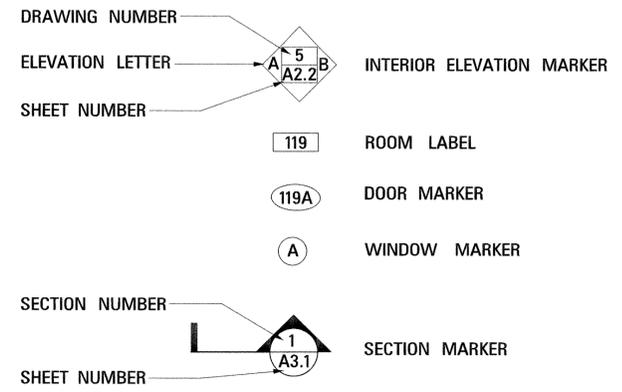

TITLE SHEET	—	1
DETAILED INDEX	DI-1	2
SITE PLAN	A1.1	3
EQUIPMENT SHED PLAN, SECTION AND DETAILS	AS1.2	4
EQUIPMENT SHED ELEVATIONS	AS2.1	5
WAREHOUSE FLOOR PLAN	AW1.2	6
WAREHOUSE BUILDING ELEVATIONS SOUTH AND WEST	AW2.1	7
WAREHOUSE BUILDING ELEVATIONS NORTH AND EAST	AW2.2	8
WAREHOUSE BUILDING SECTION	AW3.1	9
DOOR AND LOUVER DETAILS	A5.1	10
SCHEDULE	A6.1	11
WAREHOUSE FOUNDATION PLAN	SW1.1	12
WAREHOUSE FOUNDATION DETAILS	SW5.1	13
MECHANICAL LEGEND, ABBREVIATIONS, AND GENERAL NOTES	M0.1	14
SITE PLAN - MECHANICAL	M1.0	15
WAREHOUSE FLOOR PLAN - MECHANICAL	M2.1	16
MECHANICAL SCHEDULES AND DETAILS	M3.1	17
ELECTRICAL LEGEND, ABBREVIATIONS, AND GENERAL NOTES	E0.1	18
SITE PLAN - ELECTRICAL	E1.0	19
WAREHOUSE FLOOR PLAN - ELECTRICAL	E2.1	20
EQUIPMENT SHED - ELECTRICAL	E2.2	21
ELECTRICAL DETAILS, POWER RISER & SCHEDULES	E3.1	22

PLAN  
ROADWAY DESIGN DIVISION, C.A.D.D. SECTION  
MISSISSIPPI DEPARTMENT OF TRANSPORTATION

PS & E PLANS-DATE..01/05/09..		
FMS CON. # 501963/301000		
FMS CON. # 501977/301000		
REVISIONS		
DATE	SHEET NO.	BY

MISSISSIPPI DEPARTMENT OF TRANSPORTATION EQUIPMENT SHED AND WAREHOUSE AT SHOP COMPLEX IN JACKSON	
<b>DETAILED INDEX</b>	
BWO-9039-25(001) AND BWO-9040-25(001) HINDS CO.	
DATE	FILENAME: DI-1.DGN
DESIGN TEAM	GALTELLI
CHECKED	JWV
DATE	12/29/08
WORKING NUMBER	DI-1
SHEET NUMBER	2

ASU