

FOR DETAILED INDEX OF PLANS SEE SHEET NO. 2


STATE OF MISSISSIPPI

MISSISSIPPI DEPARTMENT OF TRANSPORTATION


RENOVATION OF REST AREAS BUILDINGS ON I-20 IN SCOTT COUNTY STATE PROJECT NO. BWO-5130-62(002) 501982/301000 AND BWO-5131-62(002) 501982/302000

I-20 EASTBOUND & WESTBOUND
SCOTT COUNTY

FED. ROAD REG. NO.	STATE	PROJECT NO.	SHEET NO.
4	MISS.		1

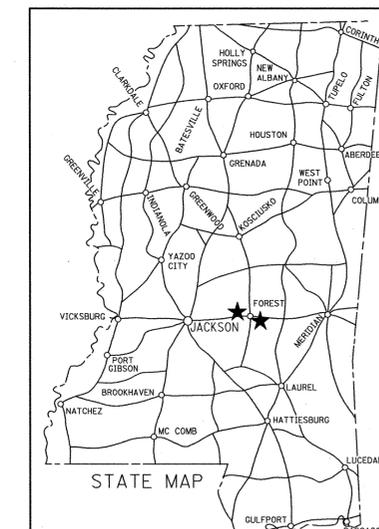

NOTE
★ INDICATES APPROXIMATE LOCATION OF PROJECT.
LATITUDE: 32.33785° N LONGITUDE: 89.55064° W
(APPROX. MIDDLE OF PROJECT)

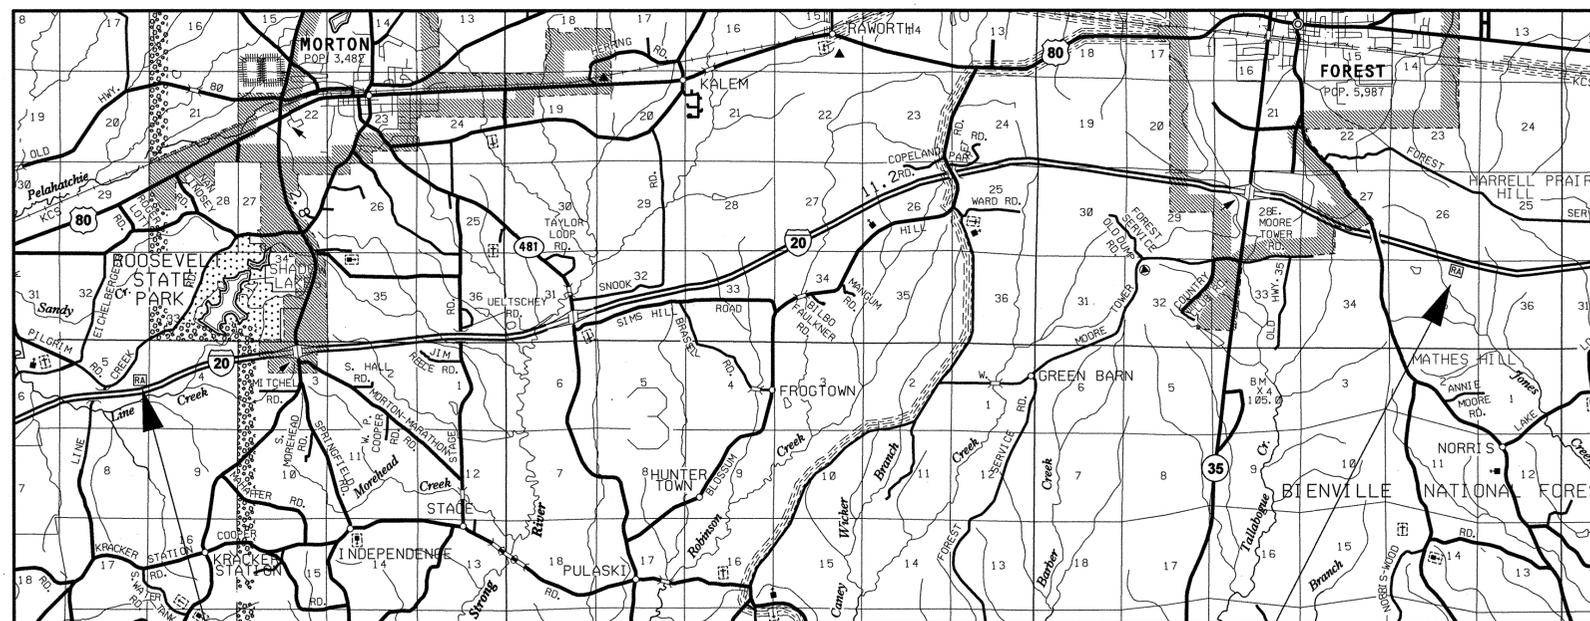

**WESTBOUND (MORTON)
REST AREA
BWO-5130-62(002)**

**EASTBOUND (FOREST)
REST AREA
BWO-5131-62(002)**

DESIGN CONTROL

MPH = V (SPEED DESIGN)

ADT () = : ADT () =

DHV = : D = % T = %

PERMITS ACQUIRED BY MDOT

WETLANDS AND WATERS PERMITS
(NECESSARY FOR ULTIMATE IMPROVEMENTS ONLY):

	WATERS	WETLANDS
NATIONWIDE #14	<input checked="" type="checkbox"/>	<input checked="" type="checkbox"/>
NATIONWIDE (OTHER)*	<input checked="" type="checkbox"/>	<input checked="" type="checkbox"/>
GENERAL*	<input checked="" type="checkbox"/>	<input checked="" type="checkbox"/>
INDIVIDUAL (404)*	<input checked="" type="checkbox"/>	<input checked="" type="checkbox"/>

* ACQUISITION OF PERMITS FOR TEMPORARY IMPACTS DURING CONSTRUCTION ARE THE RESPONSIBILITY OF THE CONTRACTOR

STORMWATER PERMIT

Y REQUIRED, CVDI SUBMITTED BY MDOT (DISTRIBUTED AREA = 5 ACRES + INTB 586)

S REQUIRED, SCNOI TO BE SUBMITTED BY CONTRACTOR (1 TO 4.99 ACRES/INTB 14)

N NO STORMWATER PERMIT REQUIRED (<1 ACRE)

APPROVED BY: *gww* DATE: 3-2-10

CONVENTIONAL SYMBOLS

- COUNTY LINE -----
- TOWN CORPORATION LINE -----
- SECTION LINE -----
- EXISTING ROAD OR TRAVELED WAY _____
- EXISTING DIVIDED HIGHWAY =====
- RAILROAD -----
- SURVEY LINE -----
- BRIDGES -----



APPROVED BY:	<i>Walter M. Butler</i>	ASU
CHIEF ENGINEER		2/26/10
EXECUTIVE DIRECTOR	<i>Scott R. Patten</i>	2/26/10
MISSISSIPPI DEPARTMENT OF TRANSPORTATION		
APPROVED:		
DIVISION ADMINISTRATOR		DATE
FEDERAL HIGHWAY ADMINISTRATION DEPARTMENT OF TRANSPORTATION		

2/26/2010 9:44 AM G00111.LDGN MISSISSIPPI DEPARTMENT OF TRANSPORTATION

DESCRIPTION OF SHEET


WKG. NO. SH. NO.

TITLE SHEET		1
DETAILED INDEX	DI-1	2
PARTIAL SITE PLAN EXISTING CONDITIONS (EASTBOUND - FOREST)	A1.1	3
PARTIAL SITE PLAN EXISTING CONDITIONS (WESTBOUND - MORTON)	A1.2	4
DEMOLITION PLANS - EASTBOUND AND WESTBOUND	A1.3	5
FLOOR PLANS - EASTBOUND AND WESTBOUND	A1.4	6
REFLECTED CEILING PLANS - EASTBOUND AND WESTBOUND	A1.5	7
BUILDING ELEVATIONS (WESTBOUND - MORTON)	A2.1	8
BUILDING ELEVATIONS (EASTBOUND - FOREST)	A2.2	9
TYPICAL ROOM ELEVATIONS	A2.3	10
TYPICAL SECTIONS AND DETAIL ELEVATIONS	A4.1	11
TYPICAL DETAILS	A5.1	12
TYPICAL DOOR AND FINISH SCHEDULE	A6.1	13
TYPICAL CONCESSION BUILDING PLAN AND ELEVATIONS	A7.1	14
PLUMBING LEGEND, ABBREVIATIONS, AND GENERAL NOTES	P0.1	15
EASTBOUND SITE PLAN - PART "A" - PLUMBING	P1.0EA	16
EASTBOUND SITE PLAN - PART "B" - PLUMBING	P1.0EB	17
EASTBOUND SITE PLAN - PART "C" - PLUMBING	P1.0EC	18
EASTBOUND SITE PLAN - PART "D" - PLUMBING	P1.0ED	19
WESTBOUND SITE PLAN - PART "A" - PLUMBING	P1.0WA	20
WESTBOUND SITE PLAN - PART "B" - PLUMBING	P1.0WB	21
WESTBOUND SITE PLAN - PART "C" - PLUMBING	P1.0WC	22
WESTBOUND SITE PLAN - PART "D" - PLUMBING	P1.0WD	23
EASTBOUND & WESTBOUND DEMOLITION PLANS - PLUMBING	P1.1	24
EASTBOUND & WESTBOUND FLOOR PLANS - PLUMBING	P2.1	25
PLUMBING SCHEDULES AND RISERS	P3.1	26
HVAC LEGEND, ABBREVIATIONS, AND GENERAL NOTES	M0.1	27
FLOOR PLAN - HVAC	M2.1	28
HVAC DETAILS AND SECTIONS	M3.1	29
HVAC SCHEDULES AND ISOMETRIC LAYOUT	M4.1	30
ELECTRICAL LEGEND, ABBREVIATIONS, AND GENERAL NOTES	E0.1	31
EASTBOUND SITE PLAN - ELECTRICAL	E1.0	32
WESTBOUND SITE PLAN - ELECTRICAL	E1.1	33
TYPICAL RESTROOM FLOOR PLAN - LIGHTING	E2.1	34
TYPICAL RESTROOM FLOOR PLAN - POWER / COMMUNICATIONS	E3.1	35
ELECTRICAL DETAILS	E4.1	36
NORTH / SOUTH MODIFIED POWER RISER DIAGRAM	E4.2	37
ELECTRICAL SCHEDULES	E4.3	38

ABBREVIATIONS:

- AFF ABOVE FINISH FLOOR
- BLDG..... BUILDING
- BOTT..... BOTTOM
- CJ CONTROL JOINT
- CLR CLEAR
- CONT..... CONTINUOUS
- DET DETAIL
- DIA DIAMETER
- (E)..... EXISTING
- EA EACH
- EJ EXPANSION JOINT
- ELEC..... ELECTRICAL
- EQL EQUAL
- ETR EXISTING TO REMAIN
- EXTR..... EXTRUDED
- FF FINISH FLOOR
- FT FEET
- GC GENERAL CONTRACTOR
- MECH..... MECHANICAL
- MET METAL
- NIC NOT IN CONTRACT
- OC ON CENTER
- PL PLATE
- REINF..... REINFORCING
- SCHD..... SCHEDULE
- TYP TYPICAL

 SYMBOL LEGEND:

- DRAWING NUMBER  INTERIOR ELEVATION MARKER
- ELEVATION LETTER 
- SHEET NUMBER  ROOM LABEL
-  DOOR MARKER
-  WINDOW MARKER
- SECTION NUMBER  SECTION MARKER
- 

EROSION CONTROL QUANTITIES

PAY ITEM NO.	PAY ITEM	UNIT	WESTBOUND		EASTBOUND		TOTALS	
			PRELIM.	FINAL	PRELIM.	FINAL	PRELIM.	FINAL
907-225-A001	GRASSING	ACRE	1		1		2	
234-A001	TEMPORARY SILT FENCE	LF	1000		500		1500	
235-A001	TEMPORARY EROSION CHECKS	BALE	50		25		75	
907-237-A003	WATTLES, 20"	LF	250		250		500	
907-246-A001	SANDBAGS	LF	50		50		100	

THESE EROSION CONTROL ITEMS ARE REQUIRED TO MINIMIZE SILTATION ALONG NEW WATER AND SANITARY FORCE MAIN TRENCHES. CONTRACTOR SHALL SUBMIT AND IMPLEMENT EROSION CONTROL PLAN.

PS & E PLANS DATE : 3/02/10		
FMS CON. # 501982/301000 & 302000		
REVISIONS		
DATE	SHEET NO.	BY
3/09/10	2,16,20,21,22,23	RJB,LGP



ADD EROSION CONTROL QUANTITIES DATE: 3/09/10 LGP REVISION BY	MISSISSIPPI DEPARTMENT OF TRANSPORTATION RENOVATE REST AREA BUILDINGS ON I-20 IN SCOTT COUNTY	
	DETAILED INDEX	
	BWO-5130-62(002) AND BWO-5131-62(002) SCOTT COUNTY	
	FILENAME: DI.DGN DESIGN TEAM: PARKER CHECKED: JWV DATE: 3/02/10	WORKING NUMBER DI-1
SHEET NUMBER 2		SHEET NUMBER 2