


STATE OF MISSISSIPPI
MISSISSIPPI DEPARTMENT OF TRANSPORTATION
**PLAN AND PROFILE OF PROPOSED
STATE HIGHWAY
FEDERAL AID PROJECT NO. BR-9205-00(009)**

INSPECTION ACCESS IMPROVEMENTS AND MISCELLANEOUS REPAIRS
U.S. HIGHWAY 82 MISSISSIPPI RIVER BRIDGE
WASHINGTON COUNTY, MISSISSIPPI CHICOT COUNTY, ARKANSAS

FMS-100332/308000

STATE	PROJECT NO.	SHEET NO.
MISS.	BR-9205-00(009)	1

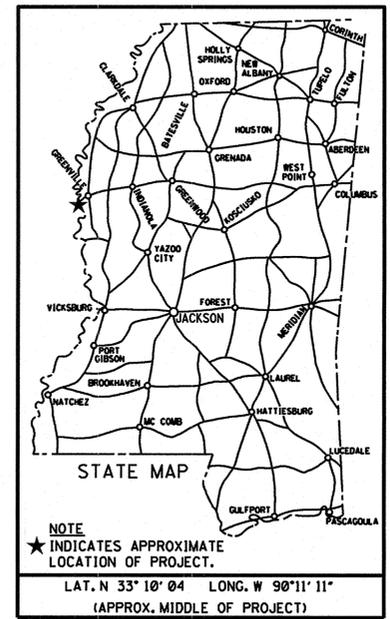

BRIDGE STRUCTURES REQ'D.


NONE

SCALES

PLAN	1:1000
PROFILE {	HOR. 1:1000
	VERT. 1:100
LAYOUT	1:2000

BOX BRIDGES REQ'D.

NONE

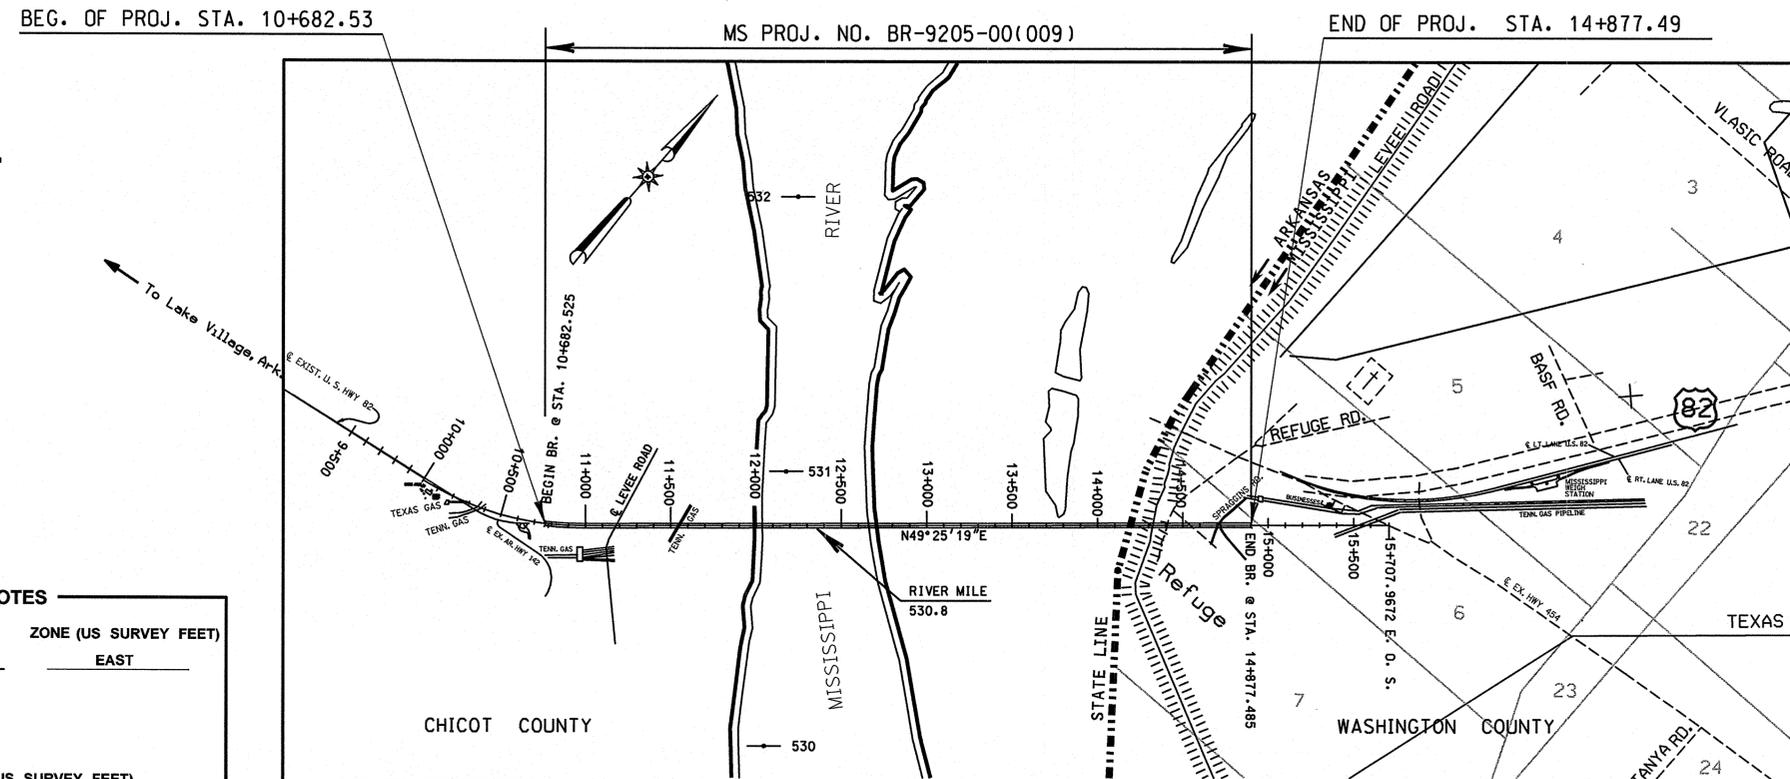

DESIGN CONTROL

N/A MPH = V (SPEED DESIGN)

ADT () = : ADT () =
DHV = : D = % T = %

PERMITS ACQUIRED BY MDOT

WETLANDS AND WATERS PERMITS (NECESSARY FOR ULTIMATE IMPROVEMENTS ONLY):

	WATERS	WETLANDS
NATIONWIDE #14	<input checked="" type="checkbox"/>	<input checked="" type="checkbox"/>
NATIONWIDE (OTHER)*	<input checked="" type="checkbox"/>	<input checked="" type="checkbox"/>
GENERAL*	<input checked="" type="checkbox"/>	<input checked="" type="checkbox"/>
INDIVIDUAL (404)*	<input checked="" type="checkbox"/>	<input checked="" type="checkbox"/>

* ACQUISITION OF PERMITS FOR TEMPORARY IMPACTS DURING CONSTRUCTION ARE THE RESPONSIBILITY OF THE CONTRACTOR

STORMWATER PERMIT

Y REQUIRED CNOI SUBMITTED BY MDOT (DISTURBED AREA = 5 ACRES)

S REQUIRED SCANS TO BE SUBMITTED BY CONTRACTOR (1 TO 4.99 ACRES)

N NO STORMWATER PERMIT REQUIRED (<1 ACRE)

APPROVED BY: *[Signature]* DATE: 4/11/13

GPS CONTROL NOTES

HORIZONTAL DATUM:	NAD	MS	ZONE (US SURVEY FEET)
HORIZONTAL MONUMENT	NORTH	EAST	
VERTICAL DATUM:	NAVD	(US SURVEY FEET)	
VERTICAL MONUMENT		ELEVATION	

ALL AZIMUTHS AND DISTANCES ARE GRID VALUES, US SURVEY FEET


CONVERSION VALUES	PROJECT AVERAGE
GROUND TO GRID (COMBINED) FACTOR	
GRID TO GEODETIC AZIMUTH	

EQUATIONS

LENGTH DATA

	TOTAL
LENGTH OF ROADWAY	0 m
LENGTH OF BRIDGES	4195 ft
LENGTH OF PROJECT (NET)	4195 m
LENGTH OF EXCEPTIONS	0 ft
LENGTH OF PROJECT (GROSS)	4195 m

EXCEPTIONS

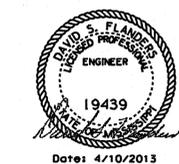

APPROVED:	<i>[Signature]</i> 4/12/13
CHIEF ENGINEER	DATE
<i>[Signature]</i>	4/12/13
EXECUTIVE DIRECTOR	DATE
MISSISSIPPI DEPARTMENT OF TRANSPORTATION	
APPROVED:	
DIVISION ADMINISTRATOR	DATE
FEDERAL HIGHWAY ADMINISTRATION DEPARTMENT OF TRANSPORTATION	

1st O.REV.

STATE	PROJECT NO.
MISS.	BR-9205-00(009)

WORKING NUMBER	SHEET NUMBER	DESCRIPTION OF SHEET
A01	1	TITLE SHEET
A02	2	DETAILED INDEX
A03	3	SUMMARY OF QUANTITIES
A04	4	PROJECT ELEVATION
A05	5	TYPICAL SECTION
A06	6	PIERS 37 & 38 ACCESS PLATFORM
A07	7	ACCESS PLATFORM PLAN DETAILS - (1 OF 2)
A08	8	ACCESS PLATFORM PLAN DETAILS - (2 OF 2)
A09	9	PIERS ACCESS LADDER AND PLATFORM DETAILS
A10	10	PIERS 36 & 39 ACCESS PLATFORM DETAILS
A11	11	INSPECTION TRAVELER RAIL SUPPORT PLAN
A12	12	TRAVELER RAIL DETAILS
A13	13	PIERS 36 & 39 EXPANSION JOINT REPAIR DETAILS
A14	14	MISCELLANEOUS REPAIR DETAILS
E1	15	ELECTRICAL GENERAL NOTES
E2	16	ELECTRICAL PLAN & ONE-LINE DIAGRAM PIER 36
E3	17	ELECTRICAL PLAN PIER 38
	18-64	TRAVELER RAIL SHOP DRAWINGS (FOR INFO ONLY)

△

PS&E PLANS - DATE 4/10/2013		
FMS CON. = 100332/308000		
REVISION		
DATE	SHEET NO.	BY
5/16/2013	2, 3, 4, 7, 10, 11, 13, 14, & 15	JPG



MISSISSIPPI DEPARTMENT OF TRANSPORTATION	
DETAILED INDEX	
PROJECT BR-9205-00(009) 100332/308000	
CHICOT/WASHINGTON COUNTY	
DESIGNED <u>SRW</u>	DETAILED <u>FWG</u>
CHECKED <u>MAI</u>	ISSUED <u>JPG</u> DATE <u>4/10/13</u>
DATE	BY
5/16/13	JPG

WORKING NUMBER	A02
SHEET NUMBER	2